

# Schenectady County Purchasing Department ADDENDUM

620 State St.-2nd Floor Schenectady, NY 12305 Purchasing@schenectadycounty.com 518.388.4240

# RFB-2022-55 SCHENECTADY COUNTY MAIN LIBRARY AHU REPLACEMENT

### **ADDENDUM #2**

### 9/28/2022

The purpose of this addendum is to provide detailed information to all Bidders and to answer questions. This addendum is hereby included in and made part of the Contract Documents, whether or not attached thereto. Receipt of this Addendum must be acknowledged on the bid form.

Some of the sections for AC-1 and AC-2 will be too large to fit through the access door or the duct opening called out to be removed/replaced for rigging. Please provide direction or any alternate solutions.

Increase the existing duct opening from 50"x50" to 64"x50". See updated drawings.

In order to rig the AHU sections to their specified locations some of the existing piping will need to removed/replaced (drain, refill, reinsulate...). Should this work be included? Yes, the existing 4" chilled water supply, chilled water returns and the 3" dual water supply piping near existing AC-2 should be remove, raised, and reinstalled as high as possible. See updated drawings

Should any alternates be awarded, can an order of importance/planned selection be provided? As it is currently designed (as individual alternates) the duct removal/replacement work would need to be included in each alternate even though the work would only need to be performed once if multiple alternates are awarded. Provide as currently designed. Unknown importance of alternates at this time.

What company services the existing Fire Alarm in the building?

## **Simplex**

The following documents is hereby included in the documents posted on Bidnet and provided to plan holders:


Please acknowledge this addendum on your bid form.

**END OF ADDENDUM #1** 



# Schenectady County Purchasing Department ADDENDUM

620 State St.-2nd Floor Schenectady, NY 12305 Purchasing@schenectadycounty.com 518.388.4240

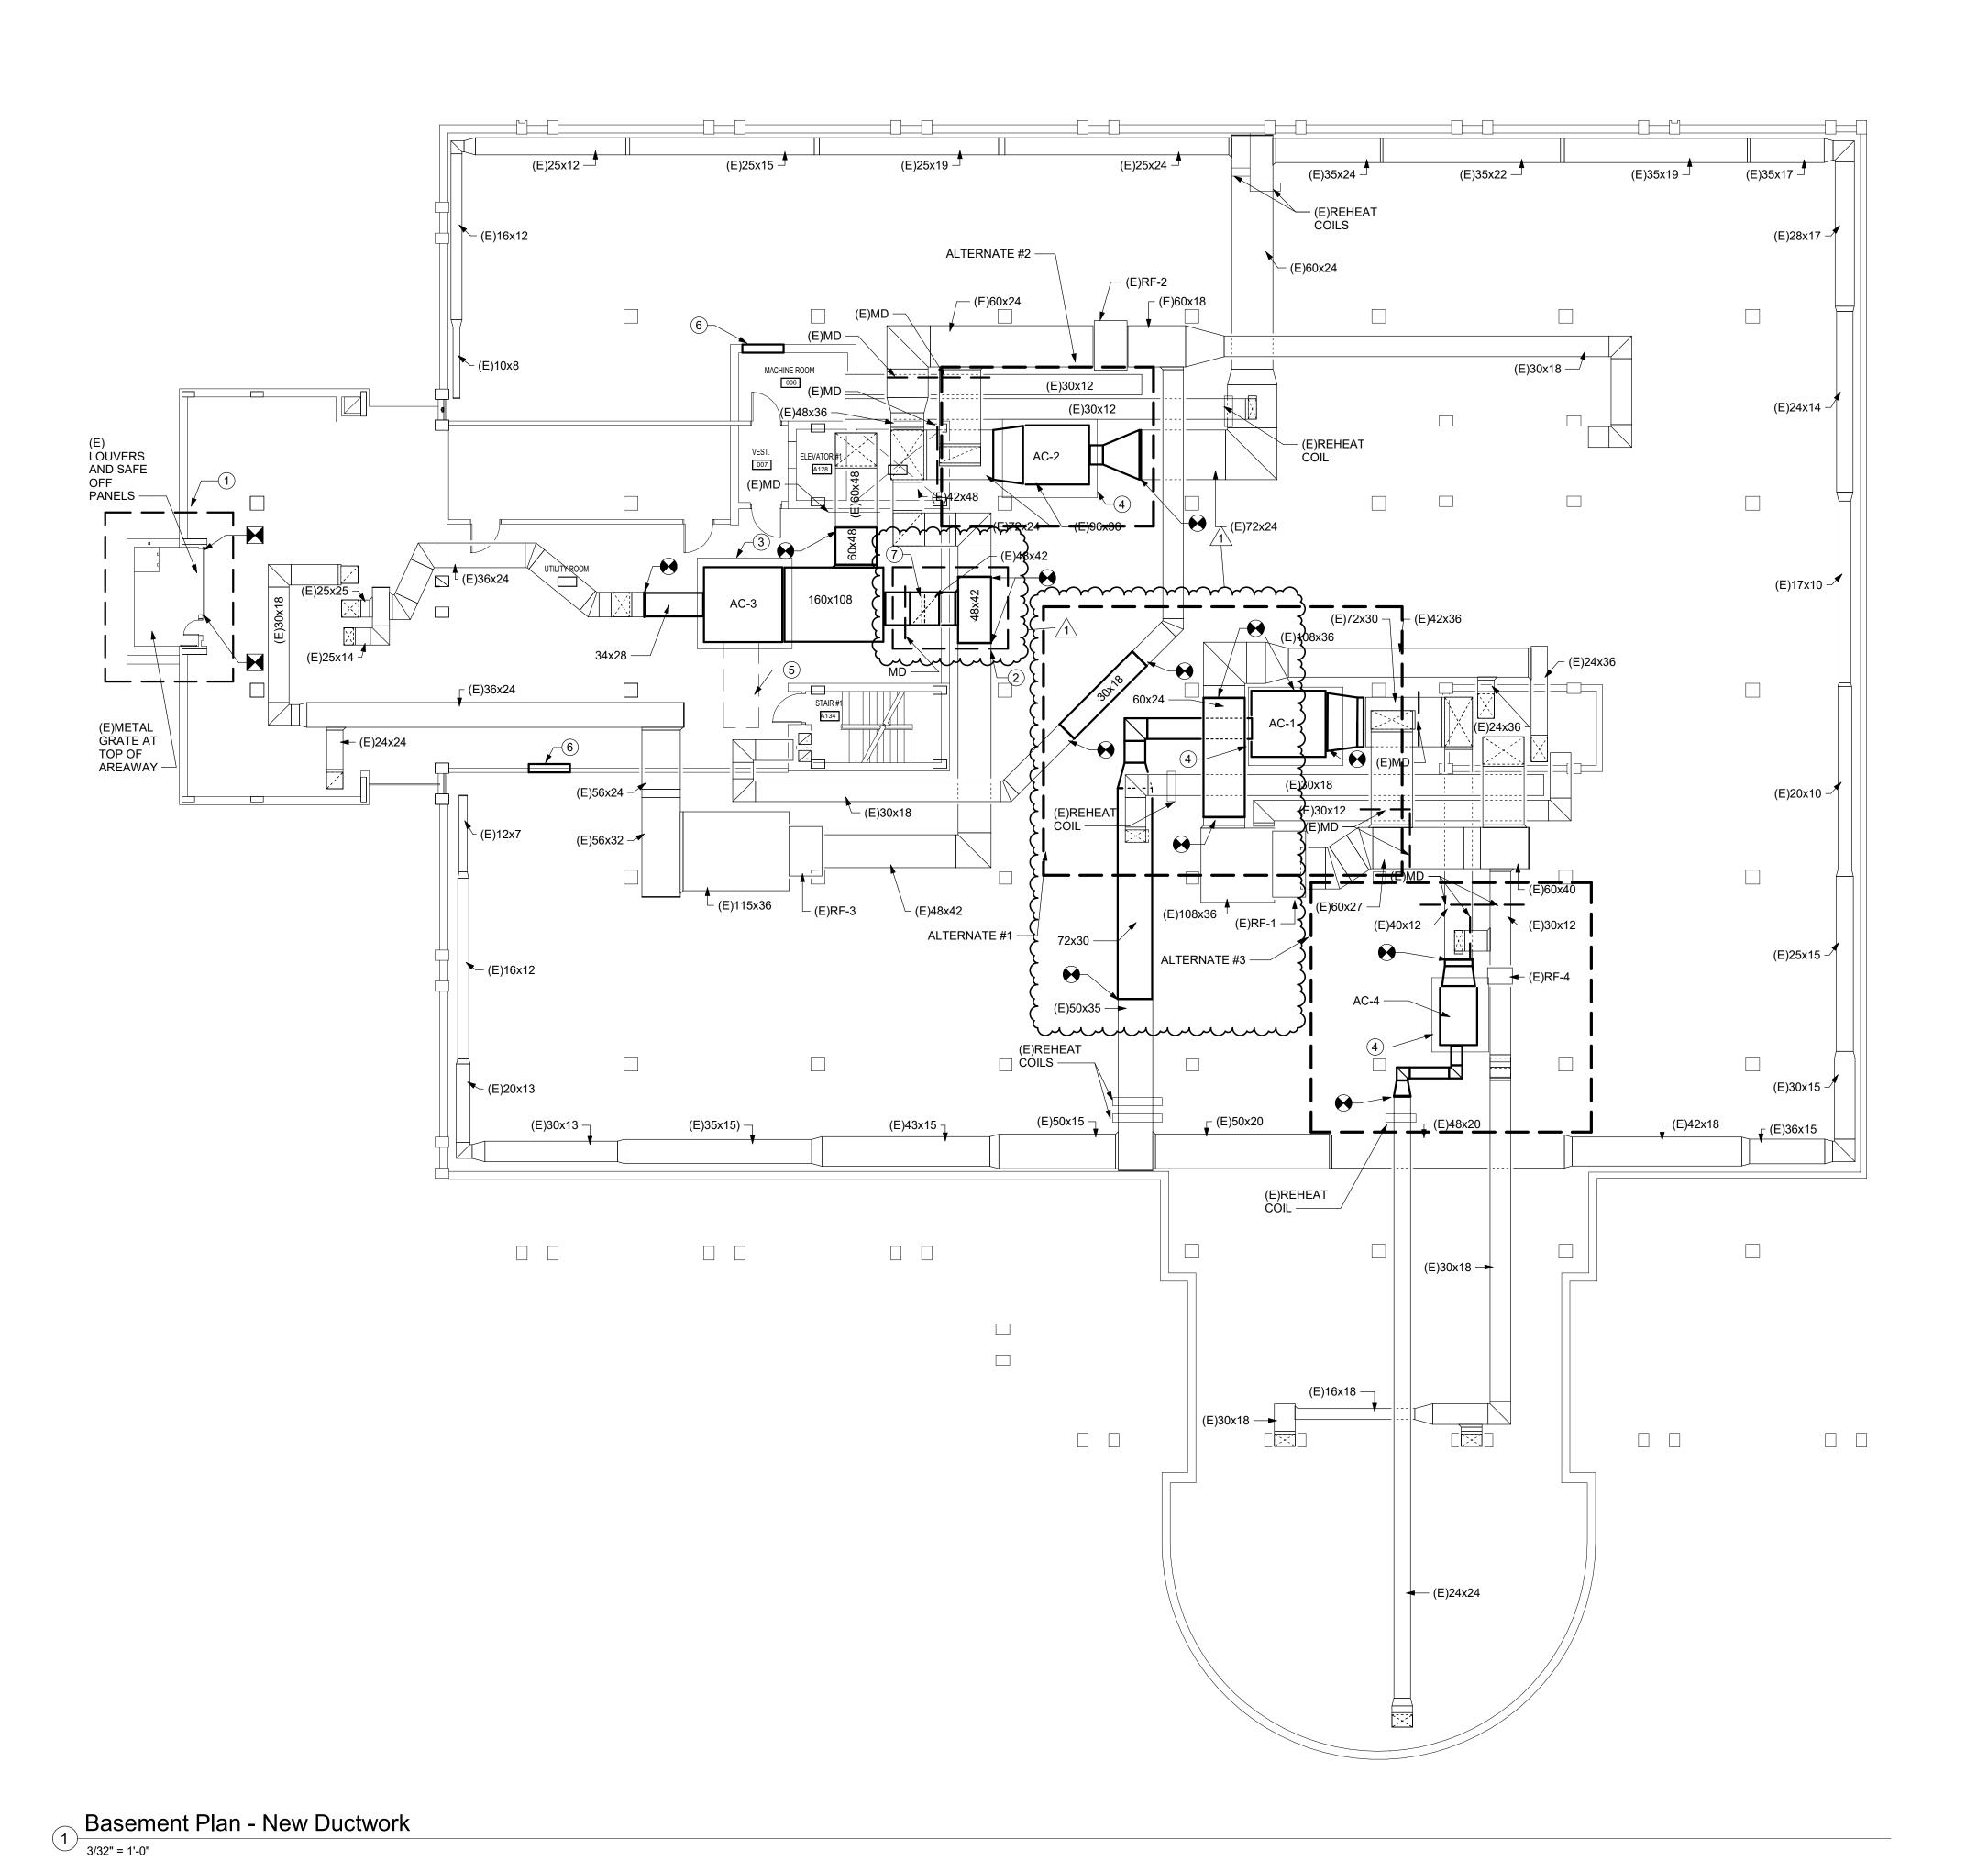

**DRAWING NOTES** 

1. AT COMPLETION OF INSTALL, REINSTALL ALL ITEMS TEMPORARILY REMOVED IN THE DEMOLITION PHASE. AND INSULATE SHEET METAL SAFING WITH 3" RIGID

-INSULATION. 2. RE-INSTALL TEMPORARILY REMOVED DUCTWORK DUCTWORK AND REINSUALTE AT COMPLETION OF

3. PROVIDE NEW PAD FULL SIZE OF UNIT AT GRADE

4. EXTEND (E)PAD TO FULL SIZE OF UNIT

5. COORDINATE COIL PULL SO COIL CAN BE PULLED IN AREA SHOWN.

6. EXISTING 40x40 ACCESS DOOR TO CRAWL SPACE. 7. SAFE OFF ENLARGED OPENING WITH 20 GAUGE SHEET METAL AND ANGLE IRON. SEAL OPENING ALL THE WAY AROUND.


AHU ARY  $\mathbf{C}$ 1B 55 5 230 20 出る日 SCI 99 SCI

**ENGINEERING** 


Mechanical/Electrical Engineering Consultants

Capital District | Rochester | Syracuse | Buffalo

433 STATE STREET, SUITE 410 SCHENECTADY, NY 12305

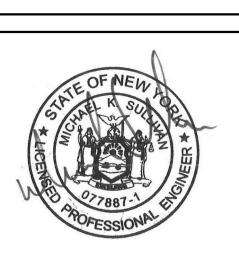

THESE DOCUMENTS AND ALL THE IDEAS,
ARRANGEMENTS, DESIGNS AND PLANS INDICATED
THEREON OR REPRESENTED THEREBY ARE OWNED BY
AND REMAIN THE PROPERT OF M/E ENGINEERING AND NO
PART THEREOF SHALL BE UTILIZED BY ANY PERSON, FIRM
OR CORPORATION FOR ANY PURPOSE WHATSOEVER
EXCEPT W/ THE SPECIFIC WRITTEN PERMISSION 2021 © M/E ENGINEERING, P.C.

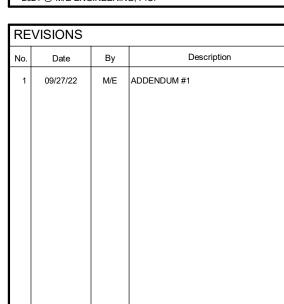


DRAWING TITLE **BASEMENT DUCTWORK PLAN** 

DRAWING NO. Checked By: MEK Project Mgr: BAB Project No: 213212

ISSUE DATE **09/02/2022** 

Project Status

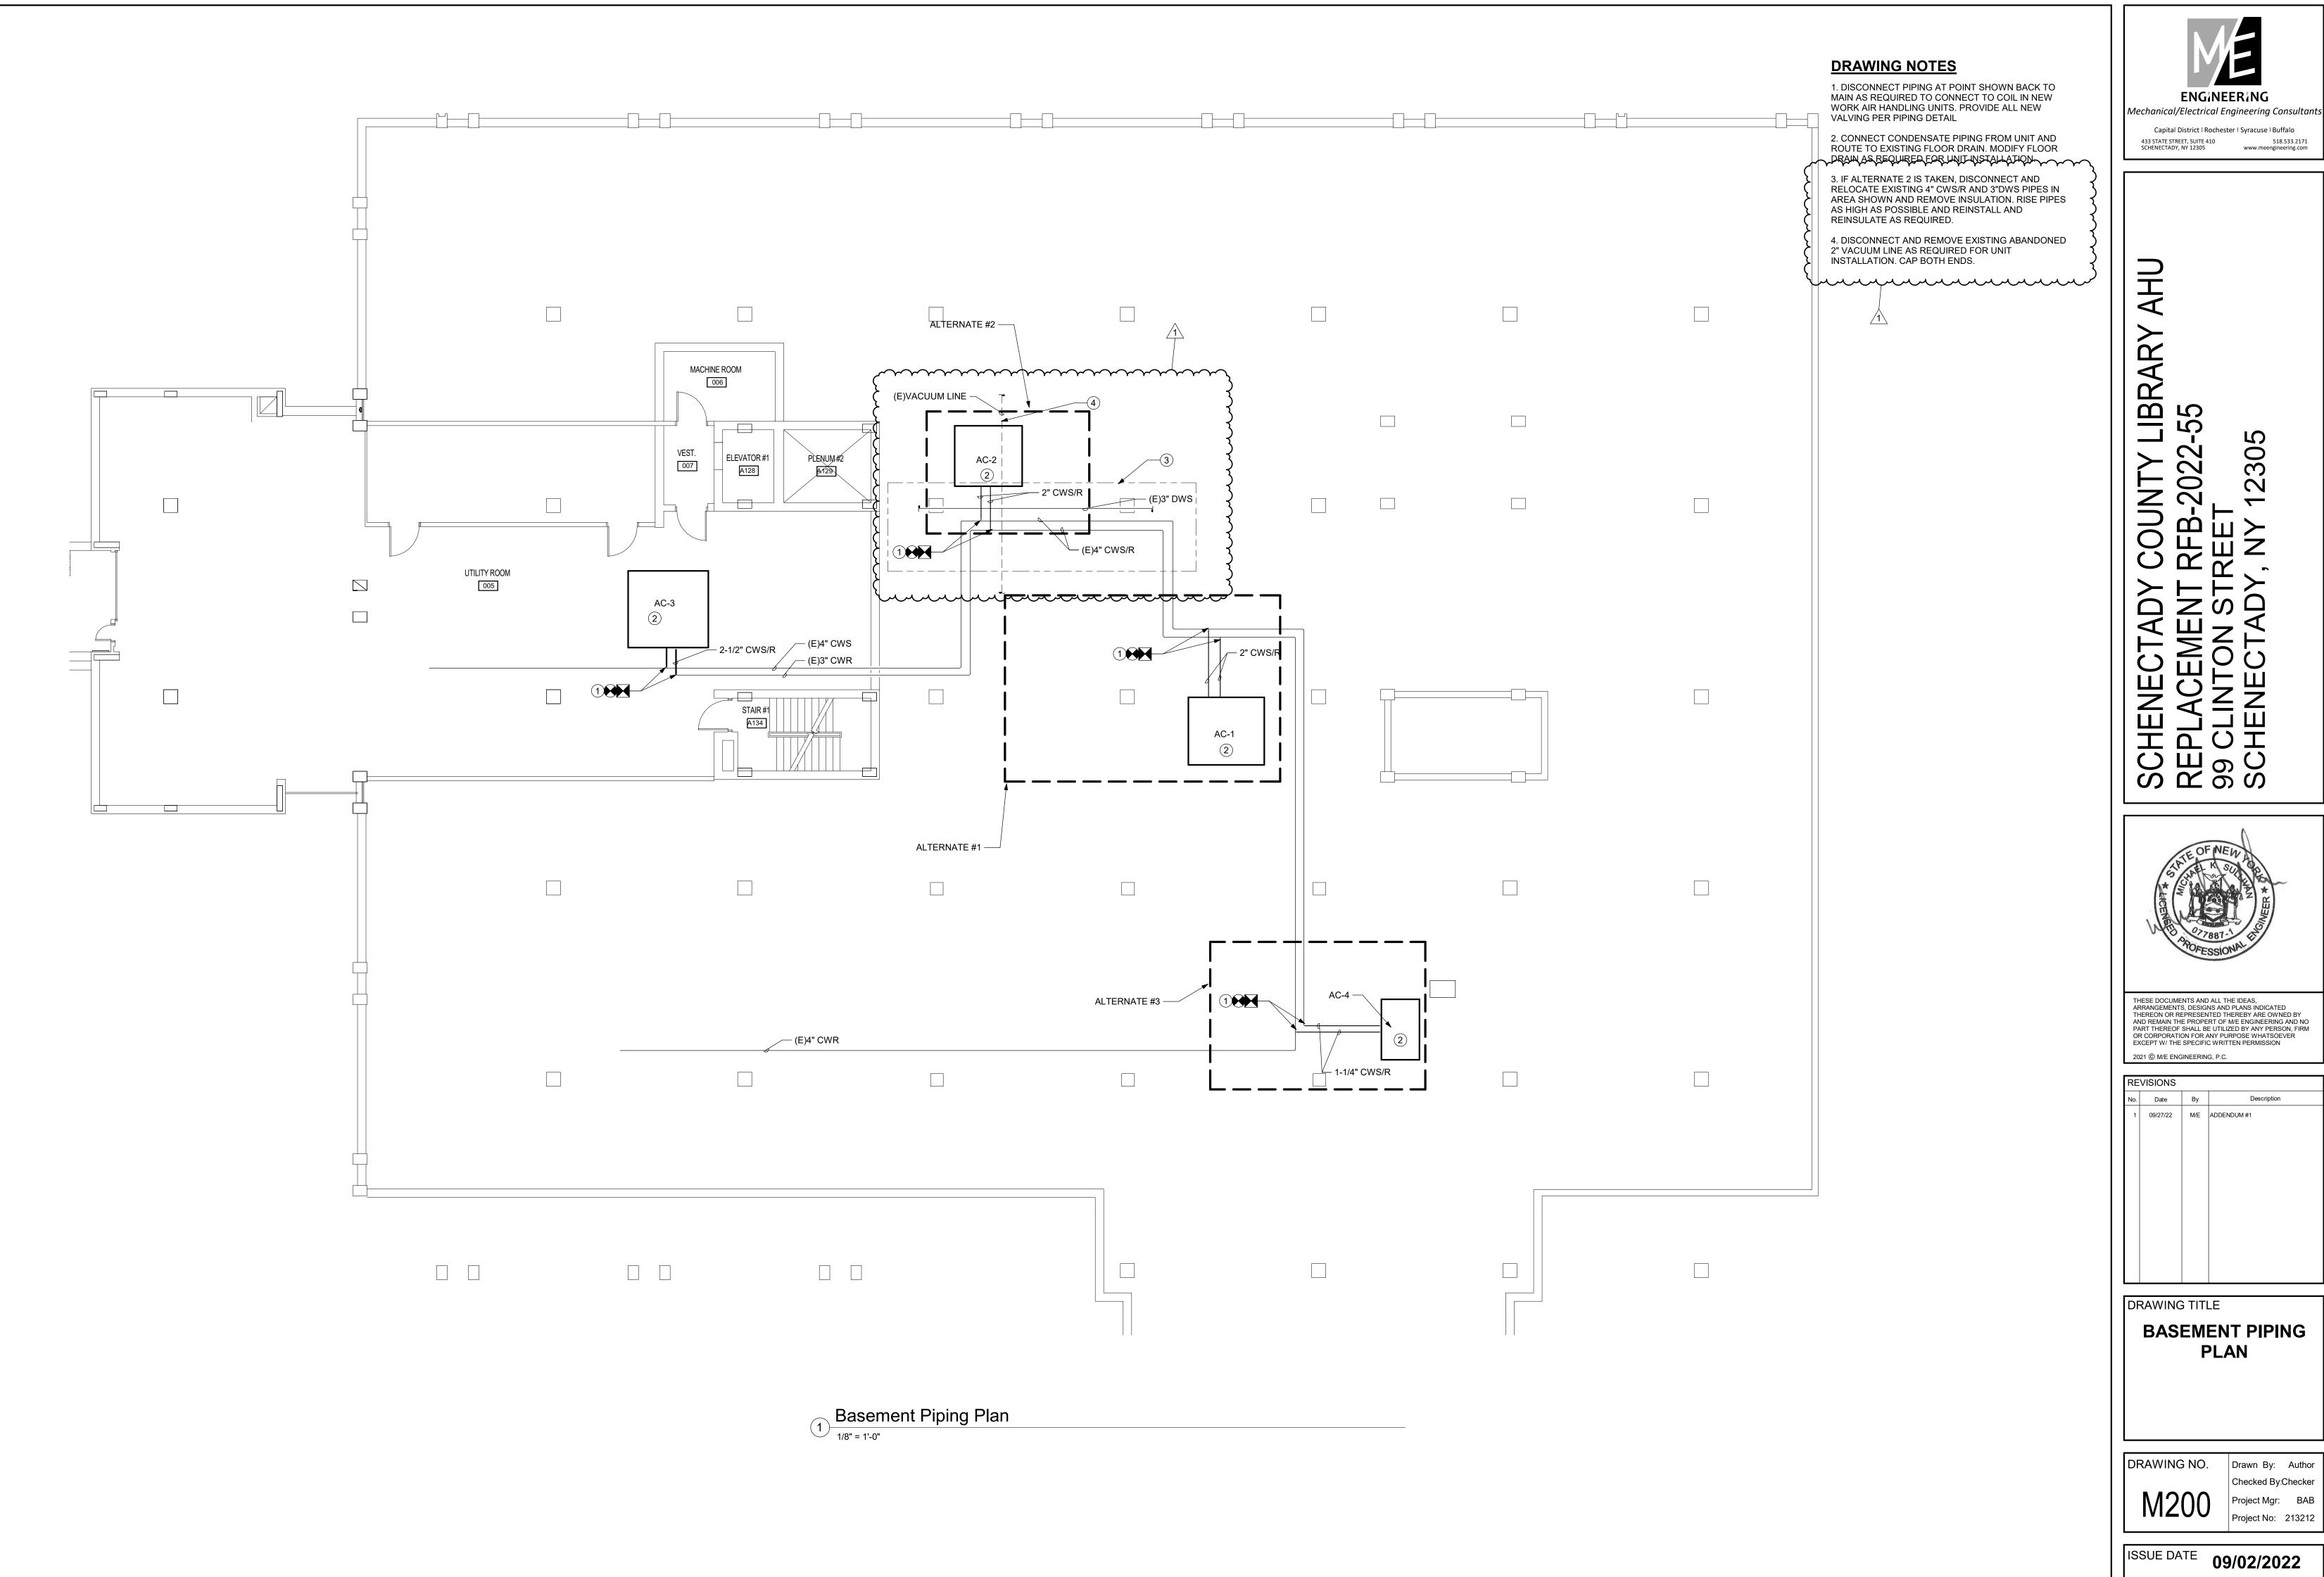

-IB| 55 200 HENECT PLACEN CLINTO HENECT SCI 99 SCI

**ENGINEERING** 

THESE DOCUMENTS AND ALL THE IDEAS,
ARRANGEMENTS, DESIGNS AND PLANS INDICATED
THEREON OR REPRESENTED THEREBY ARE OWNED BY
AND REMAIN THE PROPERT OF M/E ENGINEERING AND NO
PART THEREOF SHALL BE UTILIZED BY ANY PERSON, FIRM
OR CORPORATION FOR ANY PURPOSE WHATSOEVER
EXCEPT W/ THE SPECIFIC WRITTEN PERMISSION

REVISIONS 09/27/22 M/E ADDENDUM #1


DRAWING TITLE

**BASEMENT PIPING PLAN** 

Checked By:Checker

Project Mgr: BAB

ISSUE DATE **09/02/2022** 

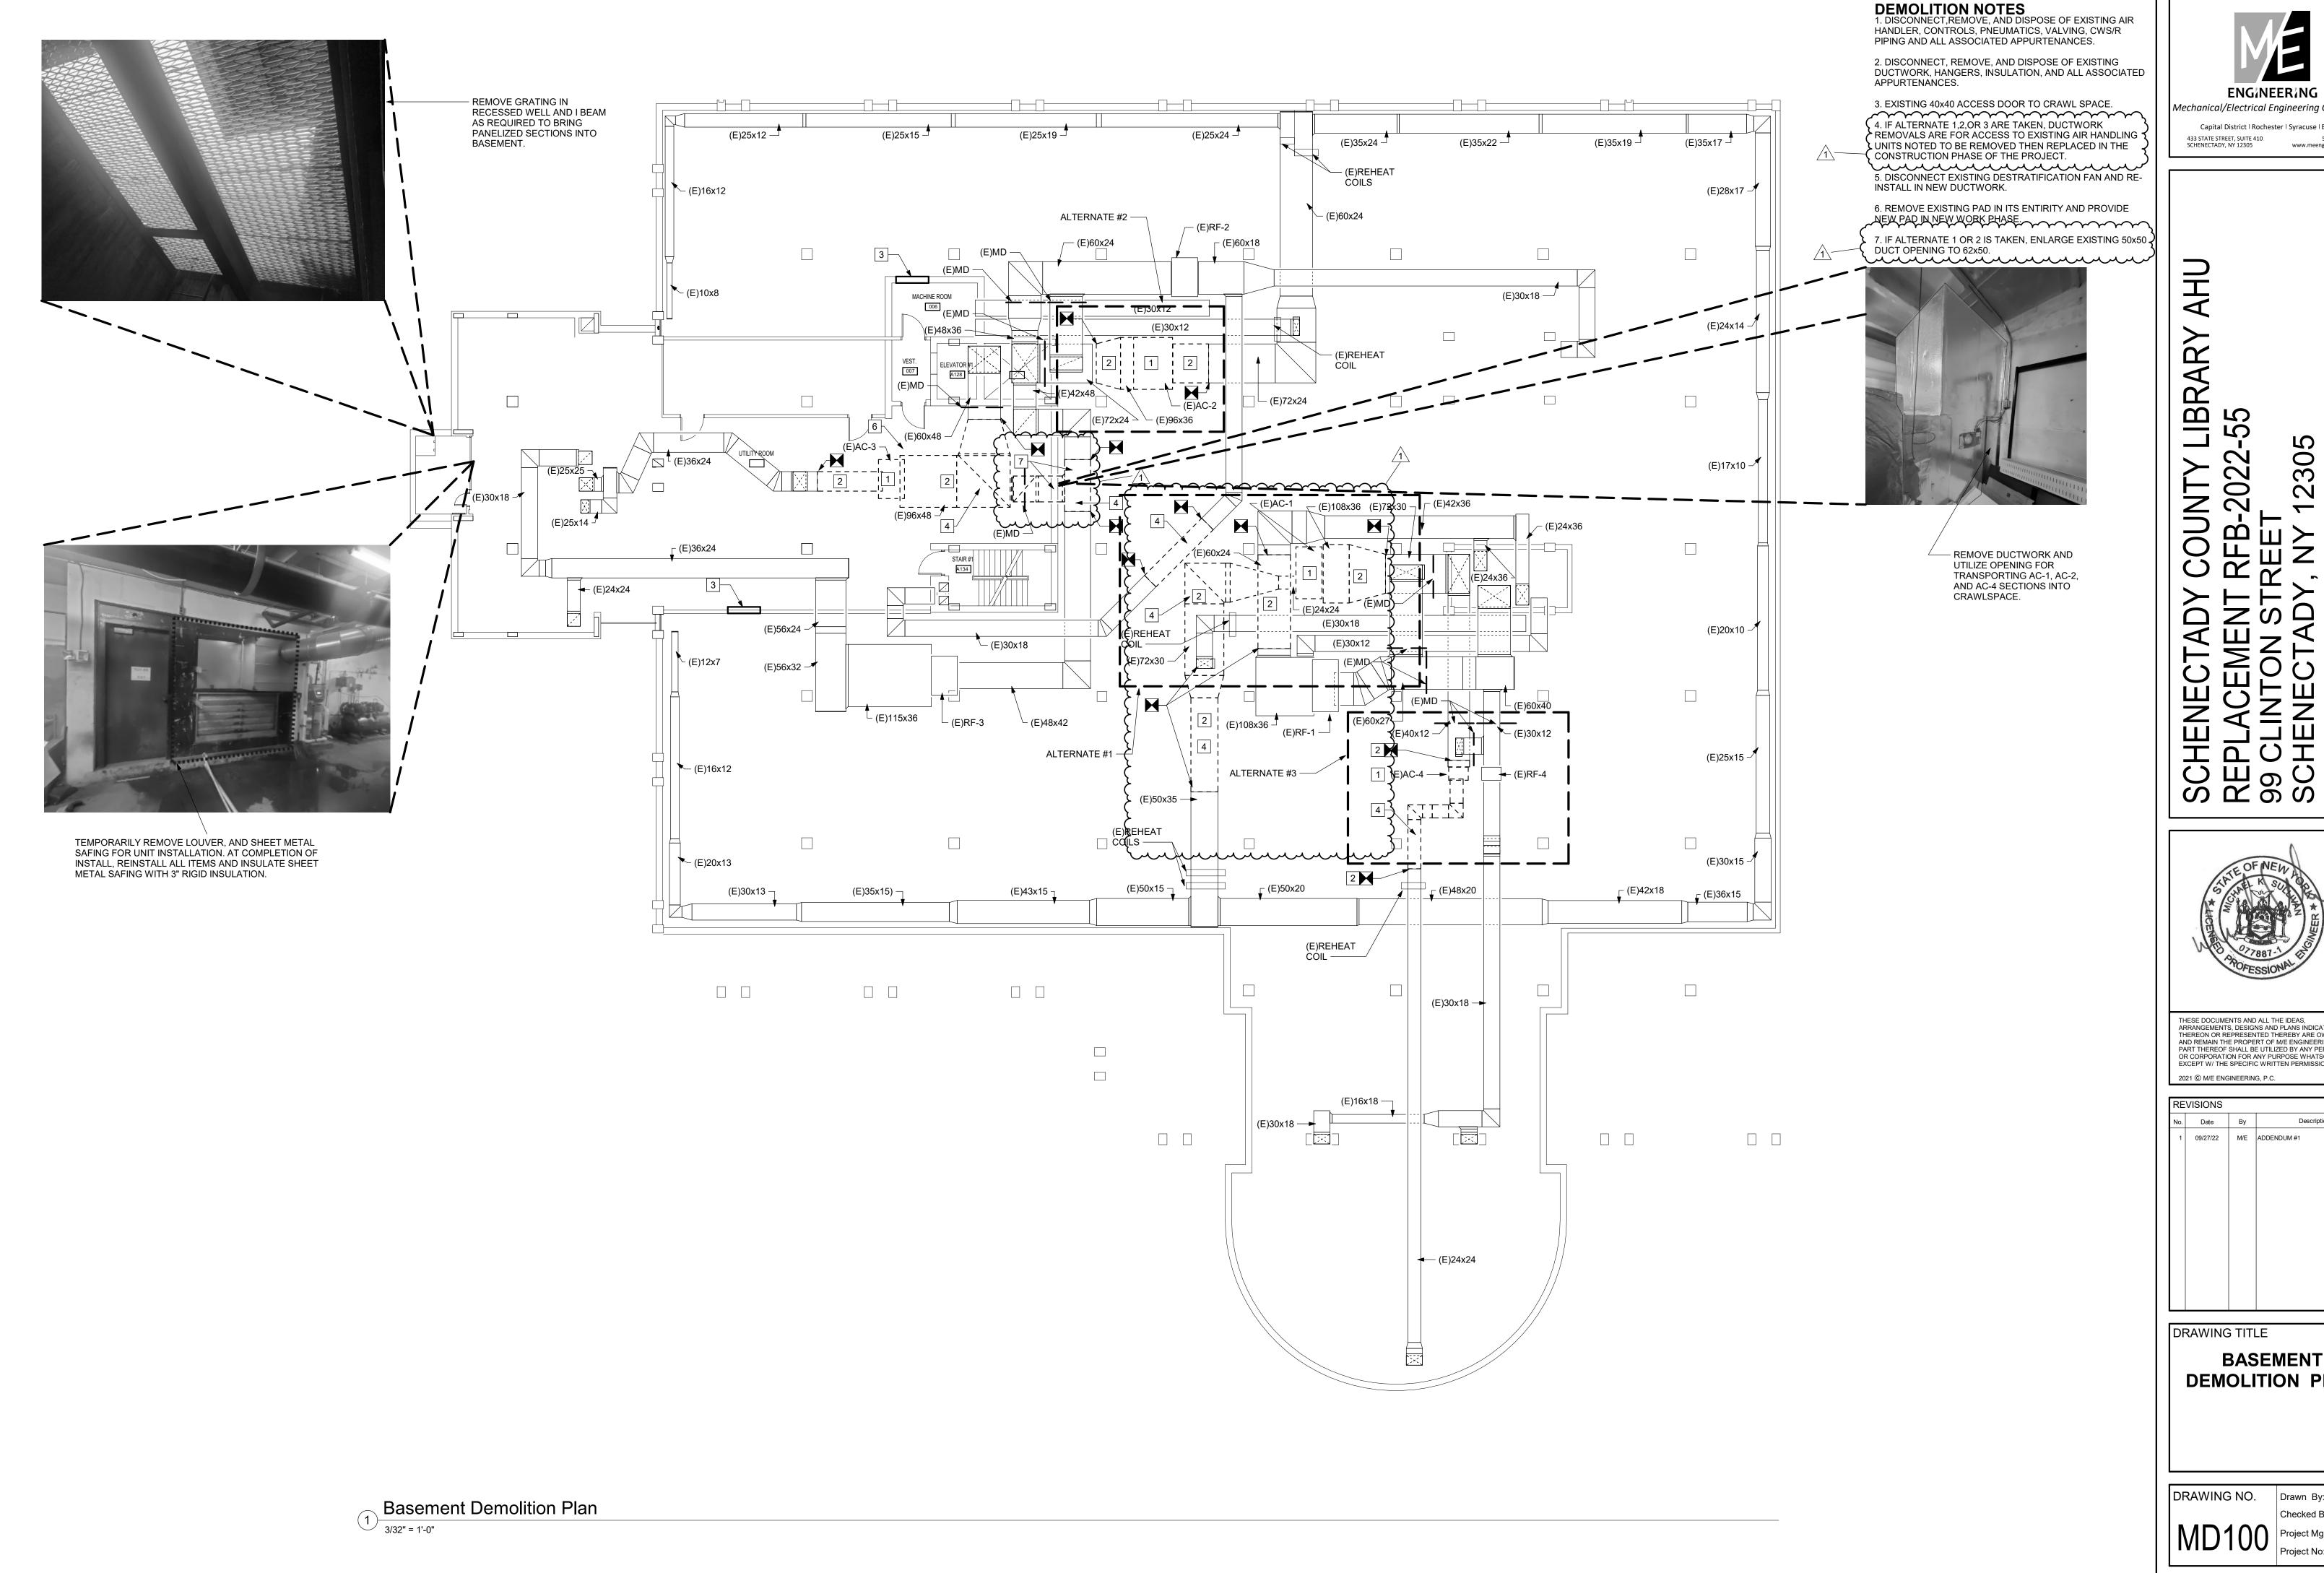

**ENGINEERING** Mechanical/Electrical Engineering Consultants

Capital District | Rochester | Syracuse | Buffalo

日の 20 Ш

THESE DOCUMENTS AND ALL THE IDEAS,
ARRANGEMENTS, DESIGNS AND PLANS INDICATED
THEREON OR REPRESENTED THEREBY ARE OWNED BY
AND REMAIN THE PROPERT OF M/E ENGINEERING AND NO
PART THEREOF SHALL BE UTILIZED BY ANY PERSON, FIRM
OR CORPORATION FOR ANY PURPOSE WHATSOEVER
EXCEPT W/ THE SPECIFIC WRITTEN PERMISSION 2021 © M/E ENGINEERING, P.C.

REVISIONS 09/27/22 M/E ADDENDUM #1

DRAWING TITLE **BASEMENT DEMOLITION PLAN** 

DRAWING NO. Checked By: MEK Project Mgr: BAB

ISSUE DATE **09/02/2022**